

INDICATIVE LIGHTING OPTIONS

- Up/down sconce lighting - placed against exterior walls
- Surface mounted downlights - placed over front door entry
- Spiked up-lighting - placed underneath feature trees



All lighting options to be confirmed with the architect and electrician.

KEY DESIGN FEATURES

- Exposed aggregate driveway
- Exposed aggregate service area
- 600mm x 1300mm exposed aggregate pavers in 13mm gravel rounds to front entry of front units
- Hardwood timber deck - flush with finished internal floor height
- Grassed lawn outdoor living area, with 50mm timber edging to garden beds
- Artificial grassed lawn outdoor living area, with 50mm timber edging to garden beds
- Gravel pathway - 13mm gravel rounds, with 50mm timber edging to garden beds and artificial lawn
- Stepped fence - refer to architects specification
- Raised planters and timber screens - refer to architects specification

AS APPROVED BY
SELWYN DISTRICT COUNCIL
Planning Department

RESOURCE CONSENT
RC245005

3/05/2024 bothac



NATURAL
HABITATS

0508 422 482
1002 Robinsons Road
www.naturalhabitats.co.nz

LANDSCAPE SET OUT + LIGHTING PLAN
George Street Units
30 George Street, Rolleston


Date 21.07.2021
Scale 1:200 @ A3
Drawn KC

Note
All dimensions must be checked on site prior to commencement.


AS APPROVED BY
SELWYN DISTRICT COUNCIL
Planning Department

RESOURCE CONSENT
RC245005

3/05/2024 bothac

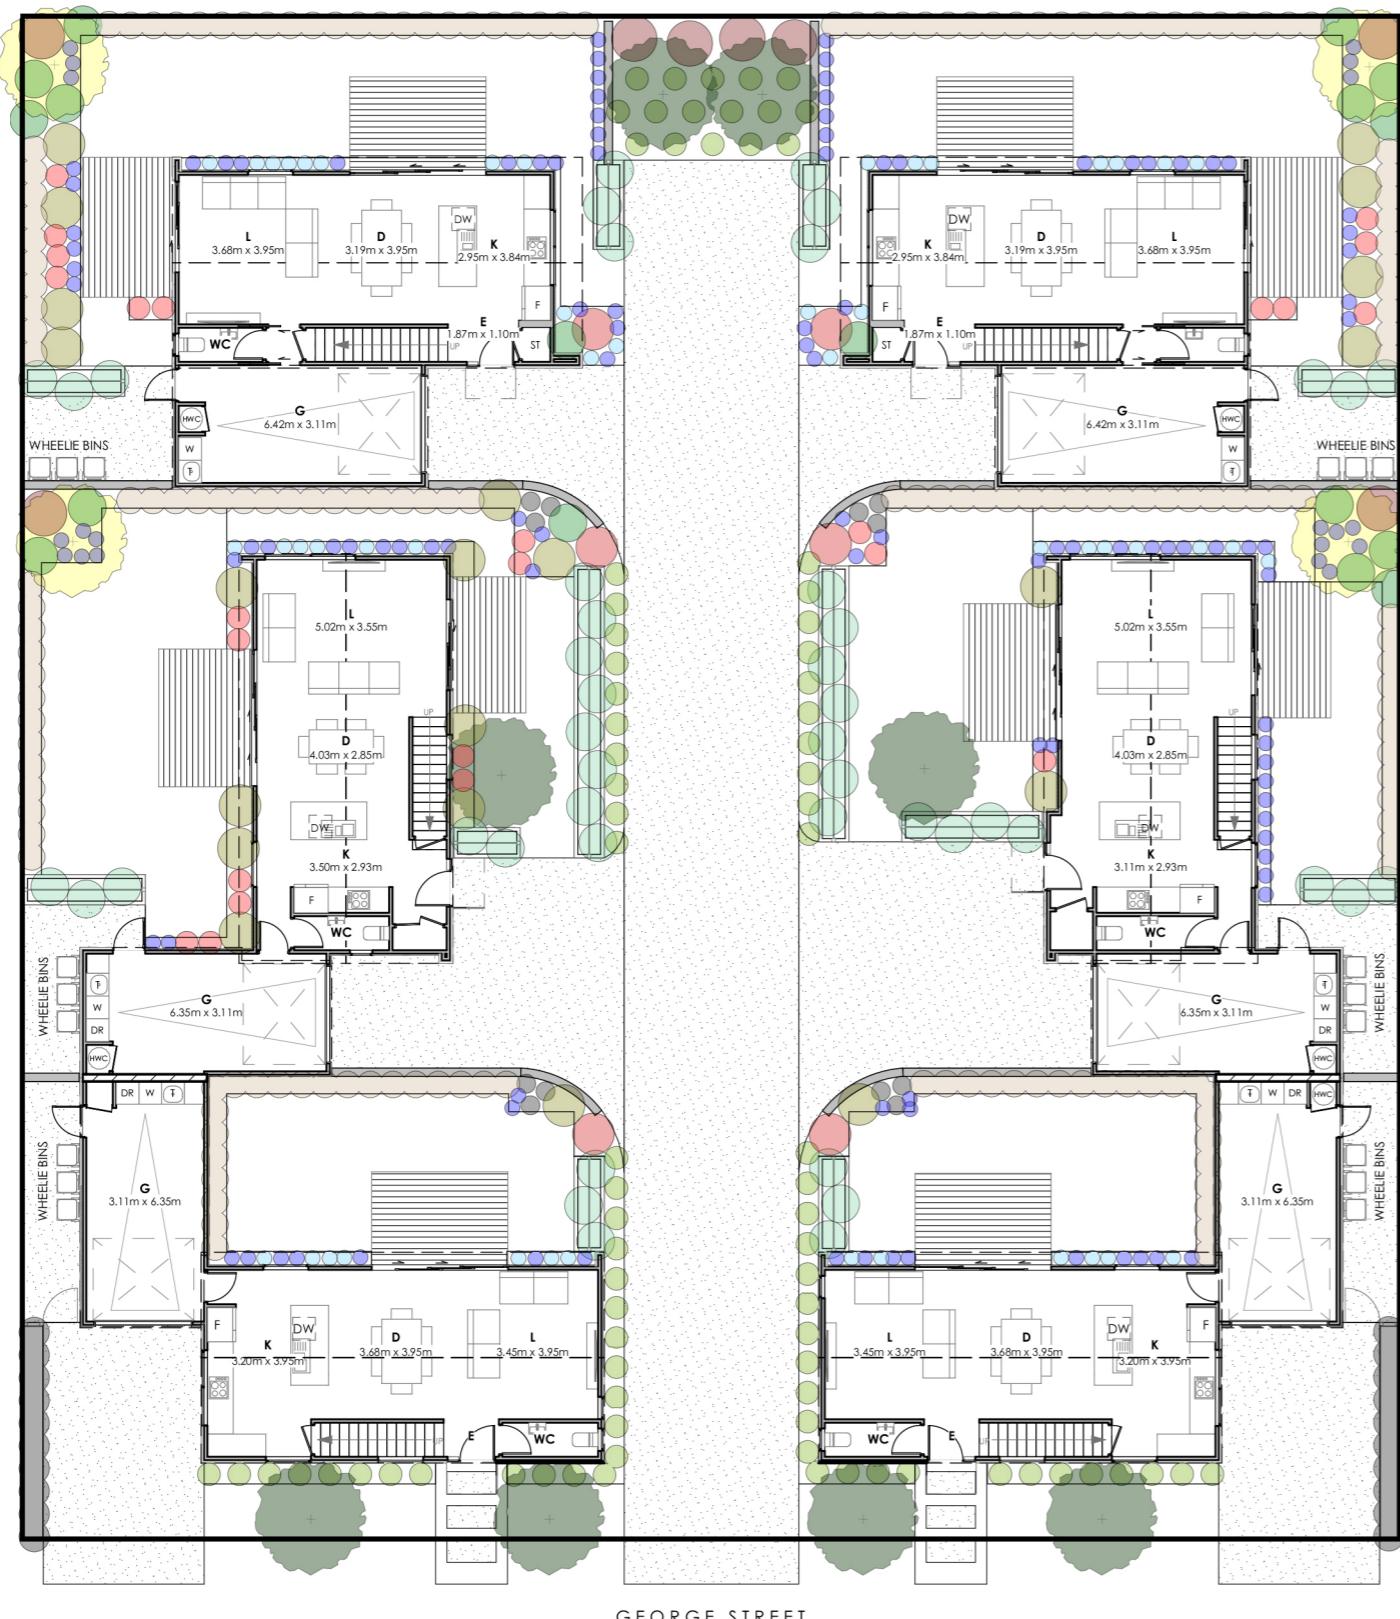

BOTANICAL NAME	COMMON NAME	QTY	PLANT TYPE	H (M)	W (M)
1. Abelia grandiflora	glossy abelia	20	Hedging	2	0.8
2. Astelia chathamica	silver spear	17	Grass/Flax	1	1
3. Corokia 'Frosted Chocolate'	corokia 'Frosted Chocolate'	166	Hedging	2	0.7
4. Dianella 'Little Rev'	Tasmanian flax lily	128	Grass/Flax	0.4	0.4
5. Haloragis purpurea	toatoa	8	Mid Shrub	1.2	1.2
6. Hebe 'Red Edge'	hebe 'Red Edge'	24	Mid Shrub	0.5	0.5
7. Hebe 'Wiri Cloud'	hebe 'Wiri Cloud'	47	Small Shrub	0.4	0.4
8. Lomandra 'Lime Tuff'	mat rush	82	Grass/Flax	0.6	0.6
9. Magnolia 'Little Gem'	Southern magnolia	8	Feature Tree	4	3
10. Muehlenbeckia complexa	shrubby pohuehue	45	Climber/Screening	2	1
11. Pittosporum 'Golf Ball'	dwarf pittosporum	21	Mid Shrub	1	1
12. Pseudopanax ferox	lancewood	12	Feature Tree	5	0.5
13. Pseudowintera 'Red Leopard'	horopito	6	Mid Shrub	1	1
14. Sophora microphylla	kowhai	4	Feature Tree	8	3

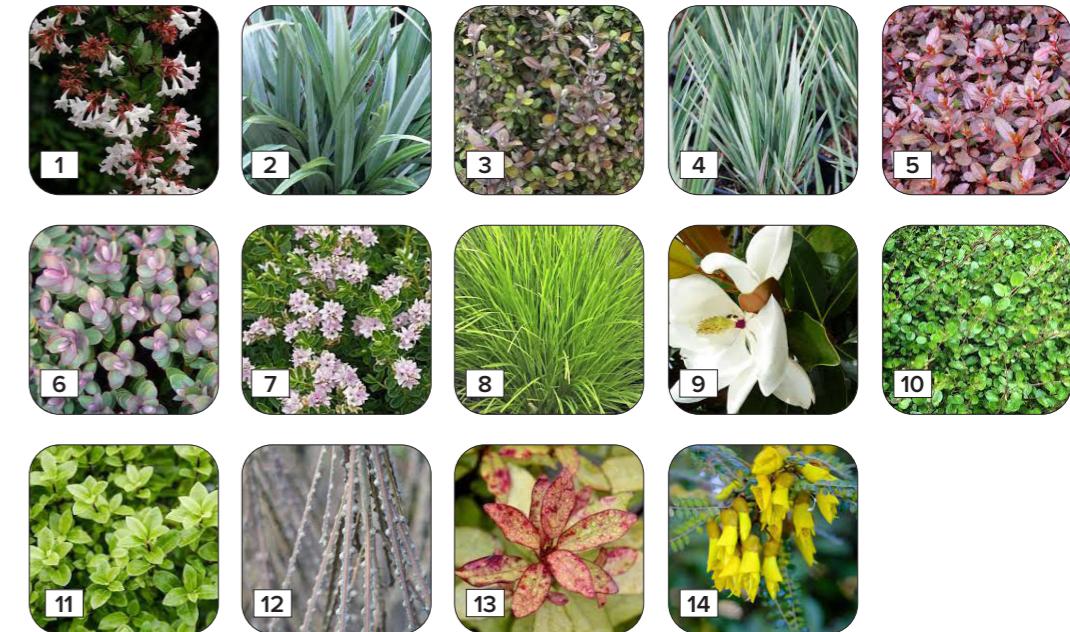

NATURAL
HABITATS

0508 422 482
1002 Robinsons Road
www.naturalhabitats.co.nz

PLANTING PLAN
George Street Units
30 George Street, Rolleston

Date 21.07.2021
Scale 1:200 @ A3
Drawn KC

Note
All dimensions must be checked on site prior to commencement.